

**MOORE PUBLIC SCHOOLS -
CENTRAL JUNIOR HIGH SCHOOL –
STEM CLASSROOM ADDITION**

Moore Public Schools - Moore, Oklahoma
AGP - Moore, Oklahoma

CONSTRUCTION BULLETIN NO. 7

February 9, 2026

1. SHEET S701 – ADDED FOOTING DETAILS 3AS701 & 3BS701. REVISED DETAILS 3S701 & 4S701.
2. SHEET A106 – REVISED ENLARGED FLOOR PLAN 1A106 AS INDICATED.
3. SHEET A107 – REVISED REFLECTED CEILING PLAN 1A107 AS INDICATED.

END OF CONSTRUCTION BULLETIN NO. 7



CJC	drawn by
BWB	checked by
FEBRUARY 2025	date
revisions	
CB-7	02/09/2026




sheet no:


S701

OWNERSHIP USE OF DOCUMENTS:


AGP EXPRESSLY RESERVES ITS
COPYRIGHT AND OTHER PROPERTY
RIGHTS OF ALL PLANS AND DRAWINGS
DESIGNED AND/OR PRODUCED. PLANS
AND DRAWINGS ARE NOT TO BE
REPRODUCED IN ANY FORM OR MANNER
WITHOUT THE EXPRESSED WRITTEN
CONSENT OF AGP.

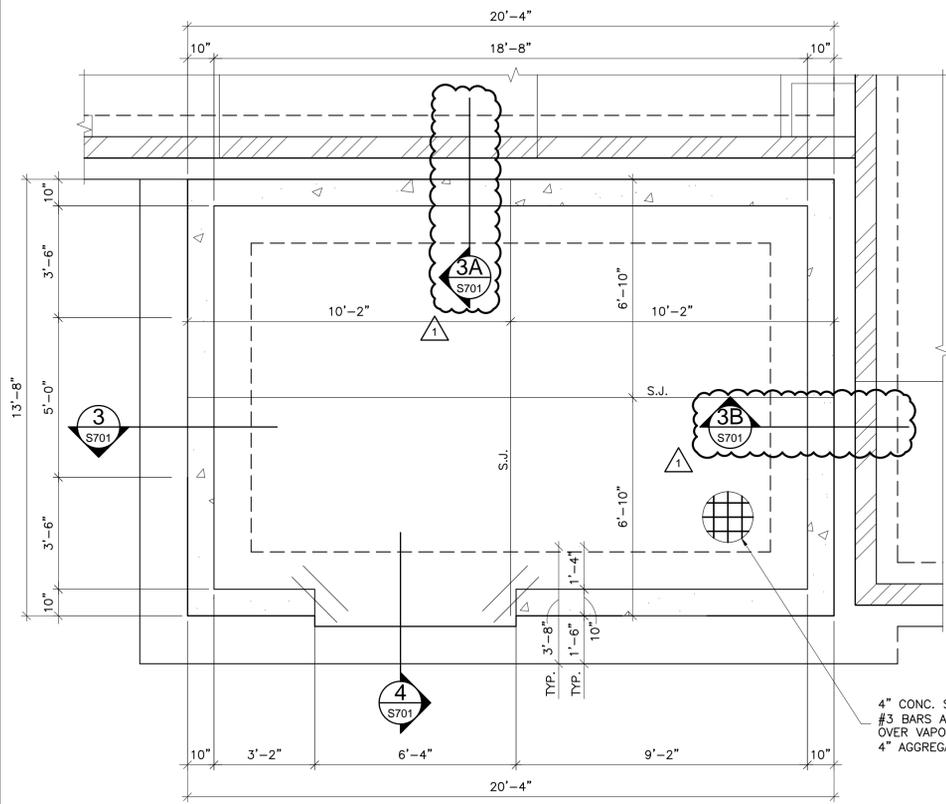


1 GENERATOR FOUNDATION PLAN
S701 SCALE: 3/8"=1'-0"

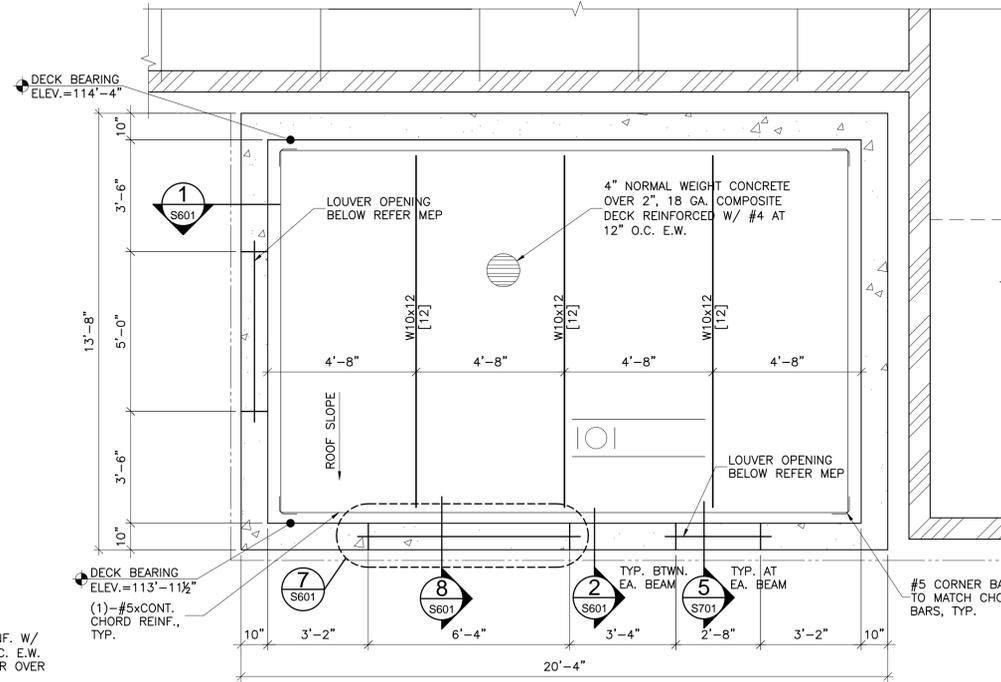


2 GENERATOR FRAMING PLAN
S701 SCALE: 3/8"=1'-0"

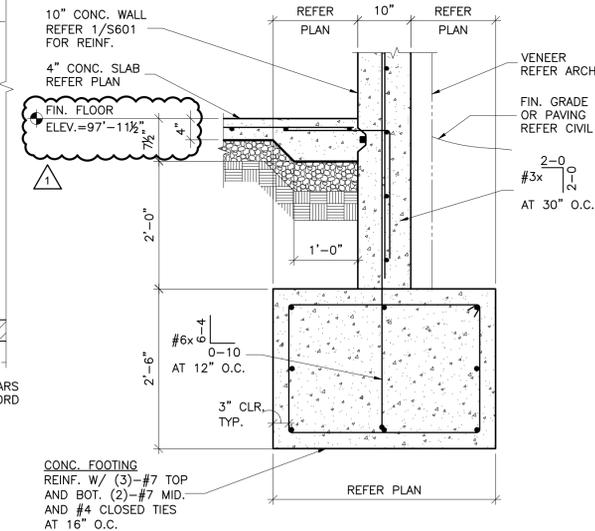


3 SECTION
S701 SCALE: 3/4"=1'-0"

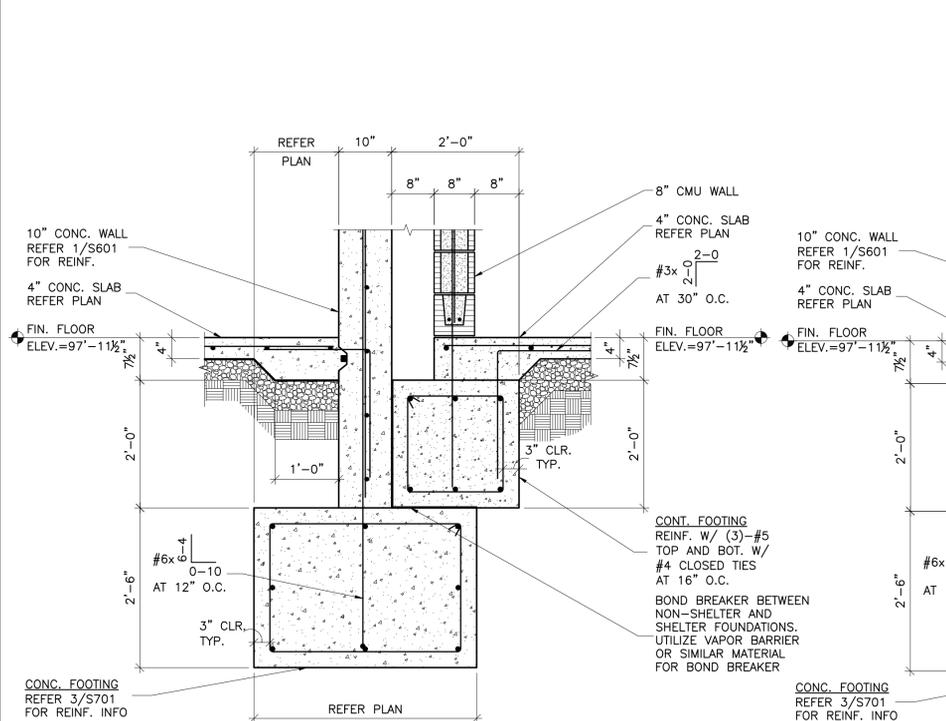


3A SECTION
S701 SCALE: 3/4"=1'-0"

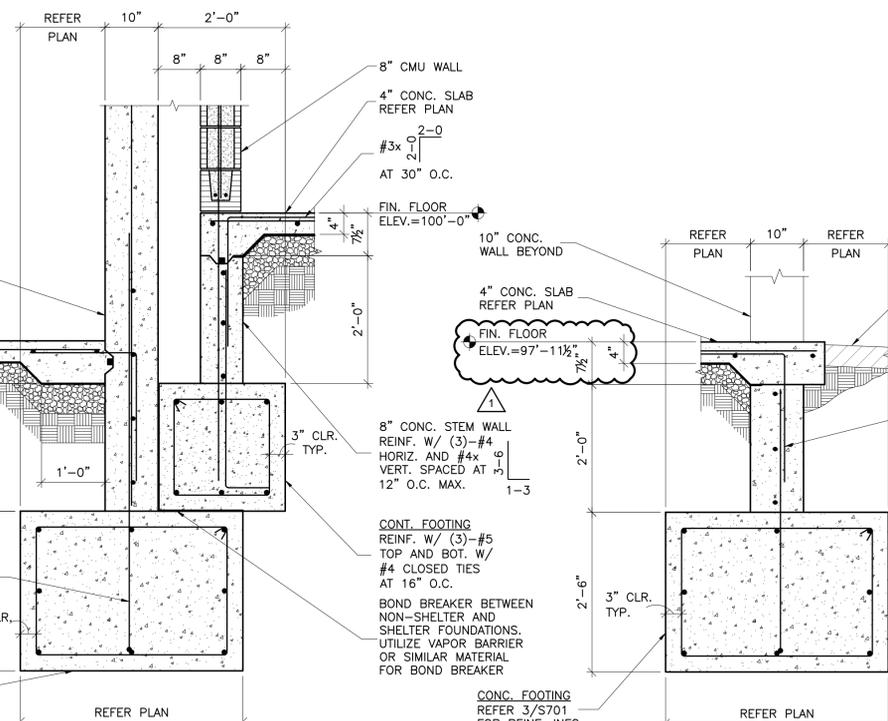

3B SECTION
S701 SCALE: 3/4"=1'-0"

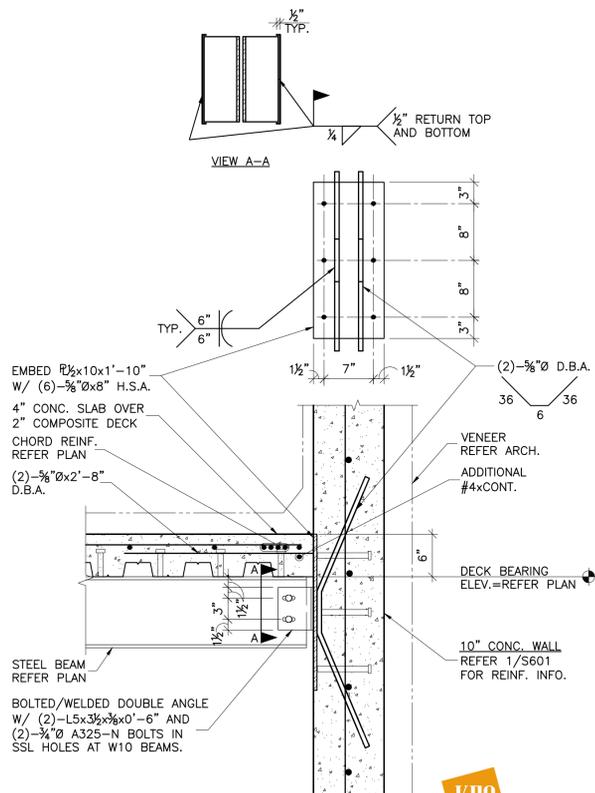

4 SECTION
S701 SCALE: 3/4"=1'-0"

 

5 SECTION
S701 SCALE: 1"=1'-0"



CG
drawn by

MA
checked by

APRIL 2025
date

revisions

1 CB-7



MOORE
PUBLIC SCHOOLS

MOORE PUBLIC SCHOOLS
BOARD OF EDUCATION
MOORE, OKLAHOMA

CLASSROOM ADDITION
CENTRAL JUNIOR
HIGH SCHOOL


sheet no:

A106

ENLARGED FLOOR PLAN

OWNERSHIP USE OF DOCUMENTS:

AGP EXPRESSLY RESERVES ITS
COPYRIGHT AND OTHER PROPERTY
RIGHTS OF ALL PLANS AND DRAWINGS
DESIGNED AND/OR PRODUCED. PLANS
AND DRAWINGS ARE NOT TO BE
REPRODUCED IN ANY FORM OR MANNER
WITHOUT THE EXPRESSED WRITTEN
CONSENT OF AGP.


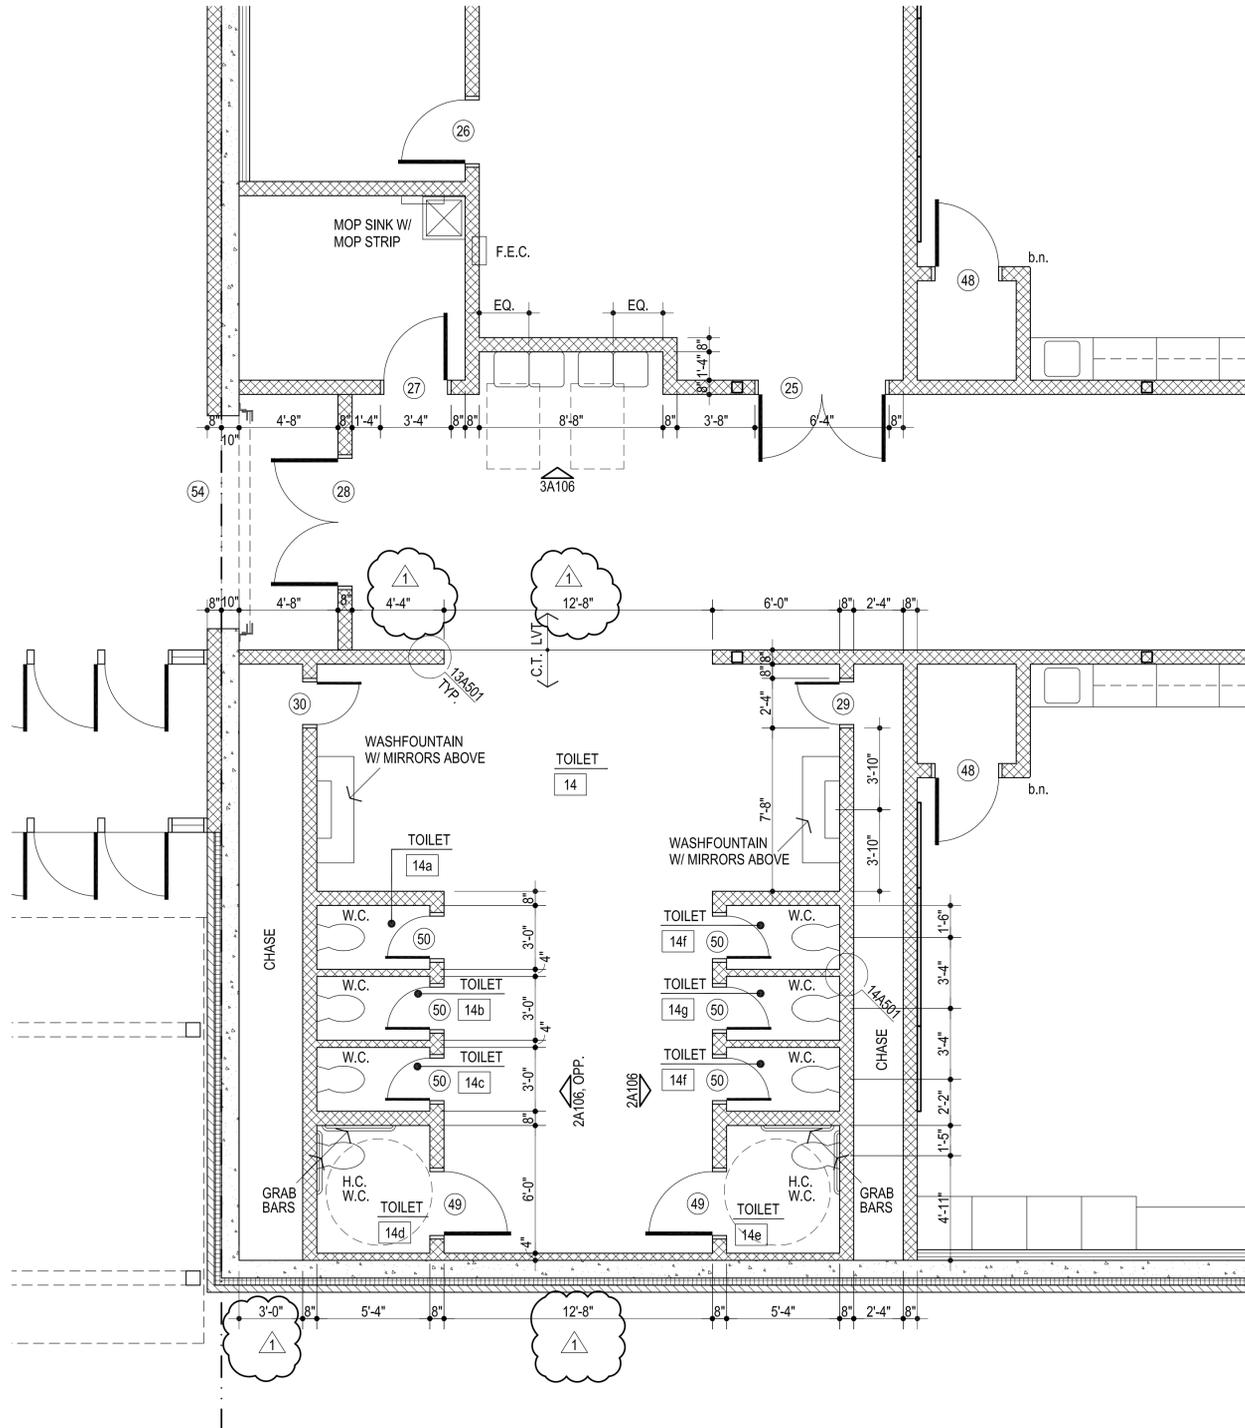


1 ENLARGED FLOOR PLAN ROOM # 14,
14a, 14b, 14c, 14d, 14e, 14f, 14g & 14h
1/4" = 1'-0"




MISCELLANEOUS NOTES:


- F.E.C. - FIRE EXTINGUISHER AND CABINET
- REFER A111 & A112 FOR FLOORING FINISH LAYOUT
- ★ INDICATES ROOM WALLS & RECESS WALLS
PAINTED ACCENT COLOR
- PROVIDE BULLNOSE @ ALL EXPOSED CMU CORNERS & ENDS (b.n.)
- DO NOT SCALE DRAWINGS TO OBTAIN MATERIAL QUANTITIES.
USE DRAWINGS WHICH ARE DIMENSIONED OR COORDINATE W/
EXISTING CONDITIONS &/OR ARCHITECT & ENGINEERS.

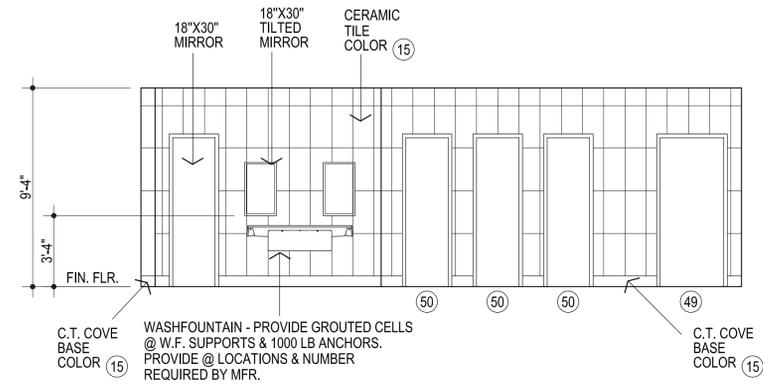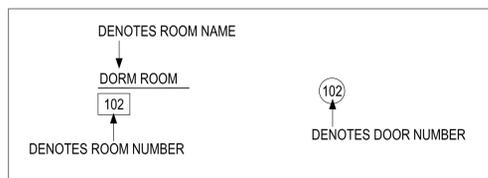


2 N. WALL - RM. #14, S. WALL OPP. - RM. #14
1/4" = 1'-0"

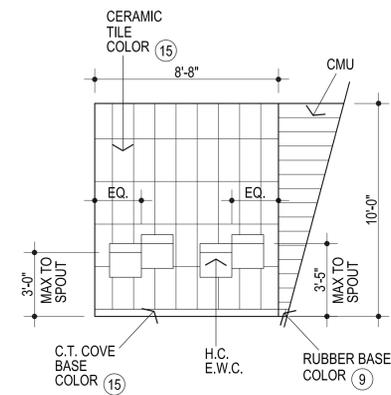

3 TYP. E.W.C. ELEVATION
1/4" = 1'-0"

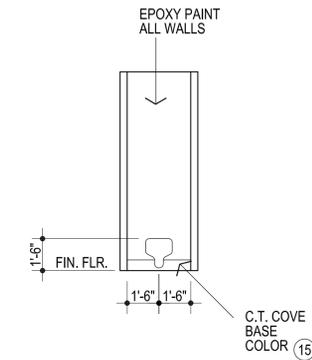

4 TYP. TOILET
1/4" = 1'-0"

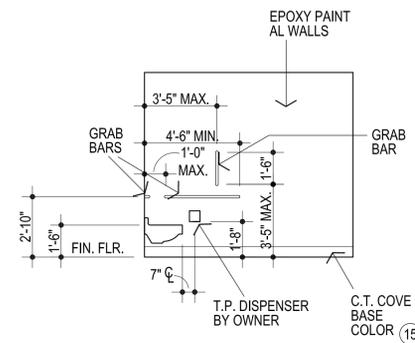

5 HANDICAP
ACCESSIBLE W.C.
1/4" = 1'-0"

NOTE: CONTRACTOR TO VERIFY THAT
THE MOUNTING HEIGHTS OF ALL WALL
MOUNTED FIXTURES (I.E. PLUMBING FIXTURES,
GRAB BARS, MIRRORS, ETC.) MEET
ALL APPLICABLE CODES & STANDARDS
PRIOR TO INSTALLATION.



CG
drawn by

MA
checked by

APRIL 2025
date

revisions

1	ADDENDUM #1
2	ADDENDUM #2
3	CB-6
4	CB-7




MOORE
PUBLIC SCHOOLS

MOORE PUBLIC SCHOOLS
BOARD OF EDUCATION
MOORE, OKLAHOMA

CLASSROOM ADDITION
CENTRAL JUNIOR
HIGH SCHOOL

sheet no:
A107
REFLECTED CEILING PLAN

OWNERSHIP USE OF DOCUMENTS:
AGP EXPRESSLY RESERVES ITS
COPYRIGHT AND OTHER PROPERTY
RIGHTS OF ALL PLANS AND DRAWINGS
DESIGNED AND/OR PRODUCED. PLANS
AND DRAWINGS ARE NOT TO BE
REPRODUCED IN ANY FORM OR MANNER
WITHOUT THE EXPRESSED WRITTEN
CONSENT OF AGP.

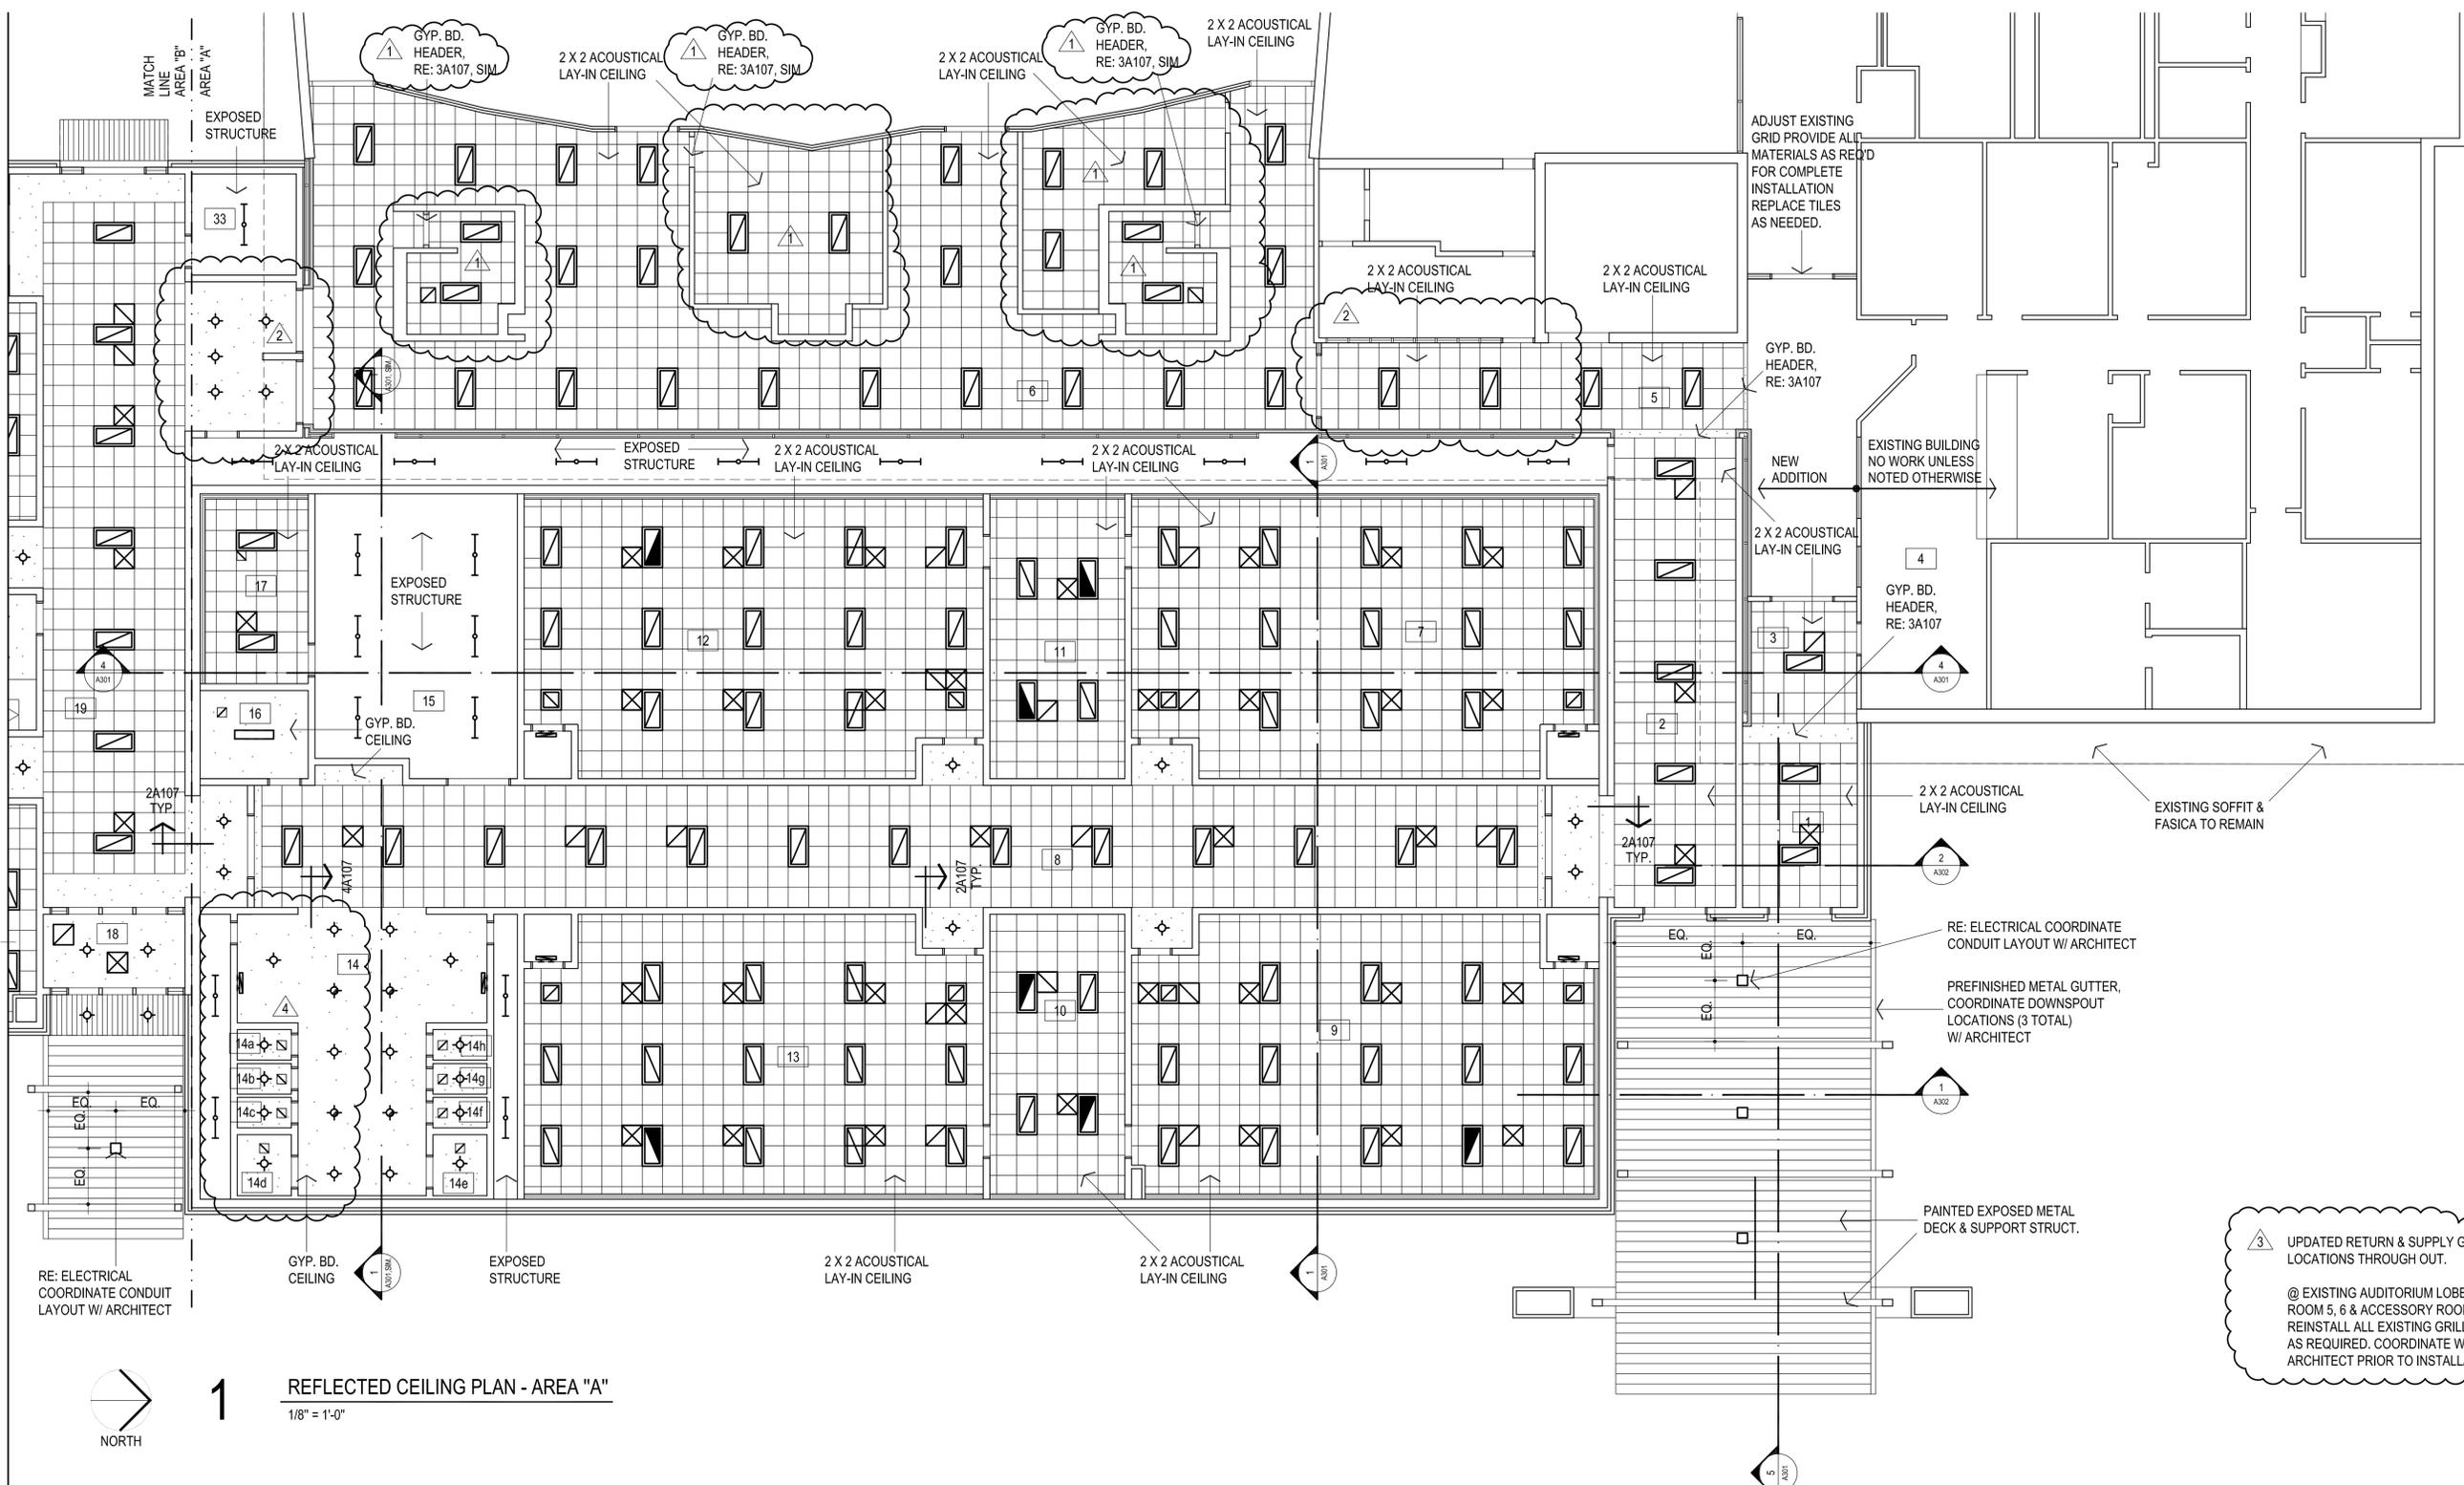

3 UPDATED RETURN & SUPPLY GRILL LOCATIONS THROUGH OUT.
@ EXISTING AUDITORIUM LOBBY - ROOM 5, 6 & ACCESSORY ROOMS, REINSTALL ALL EXISTING GRILLS AS REQUIRED. COORDINATE W/ ARCHITECT PRIOR TO INSTALLATION.

1 REFLECTED CEILING PLAN - AREA "A"
1/8" = 1'-0"
NORTH

- LEGEND:**
- MECHANICAL OPENINGS
 - ELECTRICAL FIXTURES
 - CEILING MOUNTED SMOKE DETECTOR, RE: ELEC
 - INDICATES AREA / ROOM TO RECEIVE GYP. BD. CEILING
 - INDICATES AREA / ROOM TO RECEIVE 2X2 LAY-IN CEILING

- NOTES:**
1. REFER MECHANICAL & ELECTRICAL FOR ANY ADDITIONAL CEILING MOUNTED FIXTURES
 2. REFER TO SHEET A100 FOR LOCATIONS OF FIRE-RATED WALLS
 3. DO NOT SCALE DRAWINGS TO OBTAIN MATERIAL QUANTITIES. USE DRAWINGS WHICH ARE DIMENSIONED OR COORDINATE W/ EXISTING CONDITIONS &/OR ARCHITECT & ENGINEERS.

