

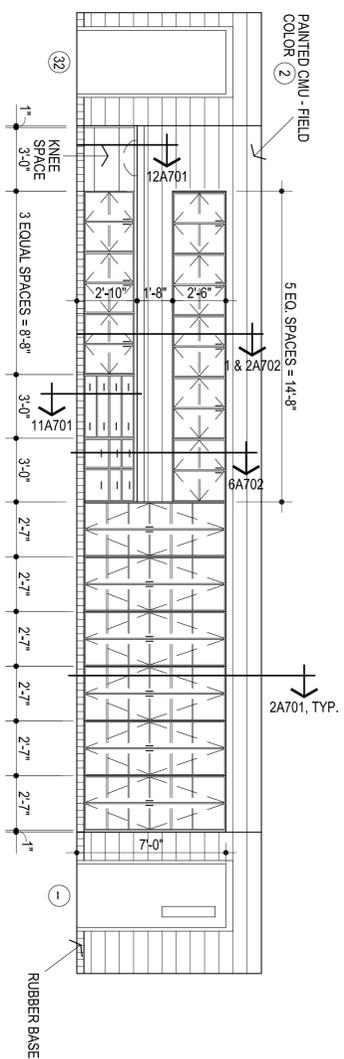


CS
Drawn by _____
MA
Checked by _____
APRIL 2025
date
revisions _____
date

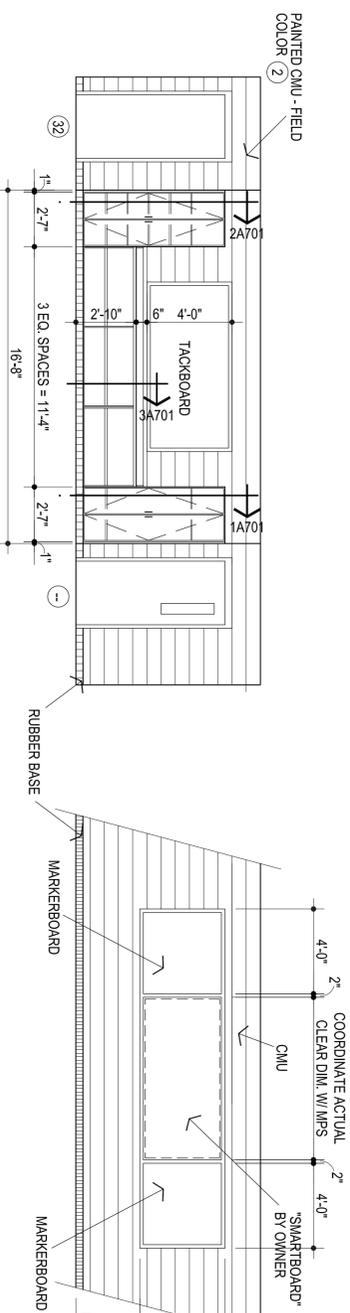


1
ELEVATION @ TYP. LAB
1/4" = 1'-0"

2
ELEVATION @ TYP. LAB
1/4" = 1'-0"

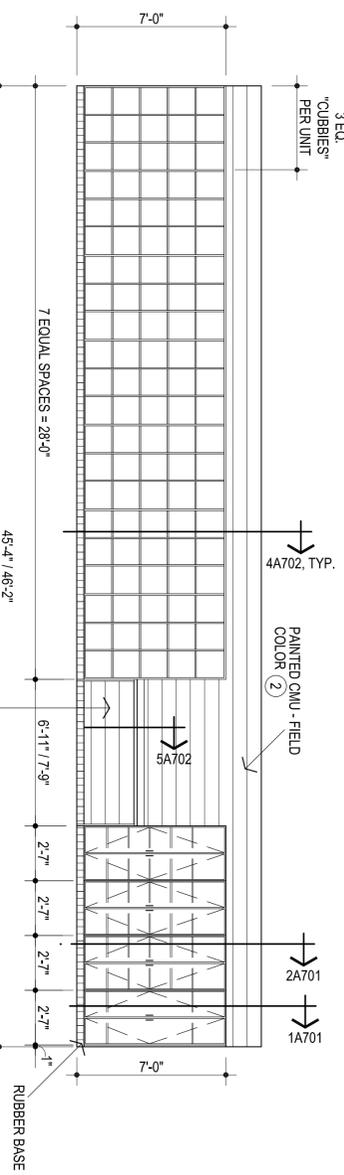


3
ELEVATION @ TYP. CLASSROOM
1/4" = 1'-0"

4
ELEV. @ TYP. CLASSROOM
"SMARTBOARD"
1/4" = 1'-0"

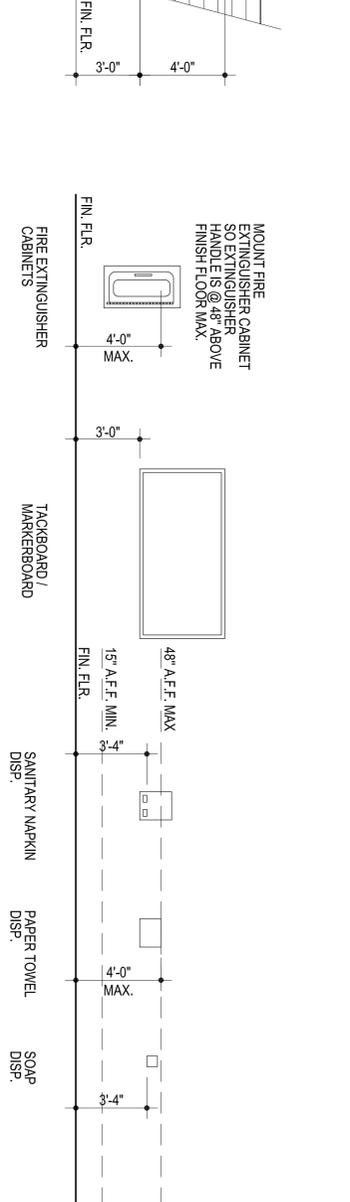


5
TYPICAL MOUNTING HEIGHTS
1/4" = 1'-0"

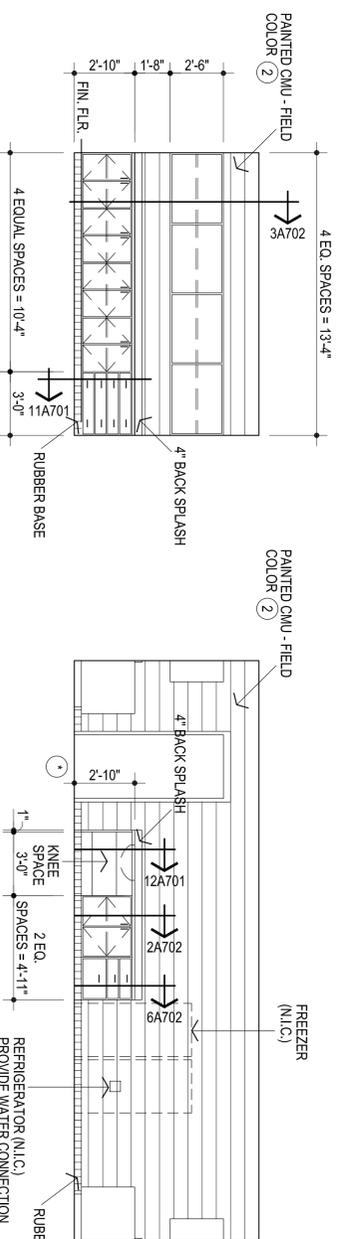


6
ELEVATION @ TYP. STORAGE ROOM
1/4" = 1'-0"

7
ELEVATION @ TYP. BASE CABINET - STORAGE ROOM
1/4" = 1'-0"

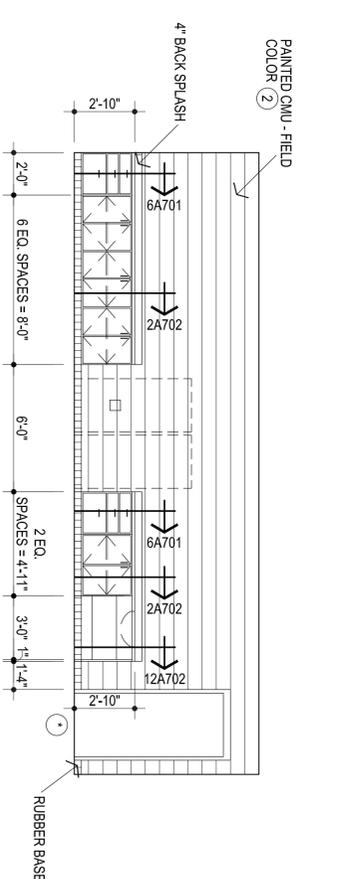

8
W. WALL ROOM #22
1/4" = 1'-0"

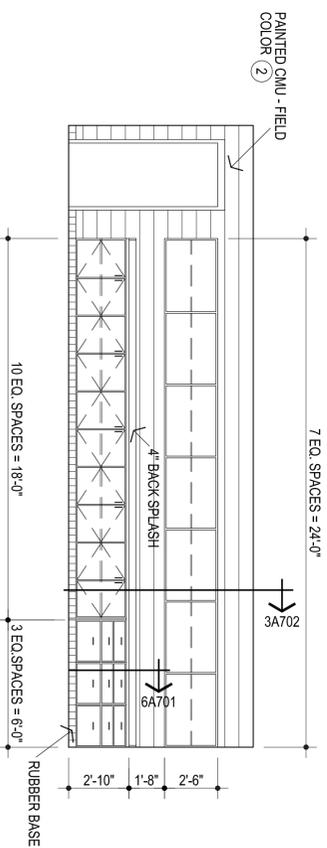

9
E. WALL ROOM #22
1/4" = 1'-0"

- GENERAL NOTES:
- DO NOT SCALE DRAWINGS TO OBTAIN MATERIAL QUANTITIES. USE DRAWINGS WHICH ARE DIMENSIONED OR COORDINATE WITH EXISTING CONDITIONS &/OR ARCHITECT & ENGINEERS.
 - NOTE: CONTRACTOR TO VERIFY THAT THE MOUNTING HEIGHTS OF ALL WALL MOUNTED FIXTURES (IE PLUMBING FIXTURES, GRAB BARS, MIRRORS, ETC.) MEET ALL APPLICABLE CODES & STANDARDS PRIOR TO INSTALLATION.