



DWG
drawn by
TVO
checked by
JANUARY 2026
date

REVISIONS

Δ	DESCRIPTION	DATE



WAYLAND BONDS
2025 HVAC

sheet no:

ED201


OWNERSHIP USE OF DOCUMENTS:
AGP EXPRESSLY RESERVES ITS
COPYRIGHT AND OTHER PROPERTY
RIGHTS OF ALL PLANS AND DRAWINGS
DESIGNED AND/OR PRODUCED. PLANS
AND DRAWINGS ARE NOT TO BE
REPRODUCED IN ANY FORM OR MANNER
WITHOUT THE EXPRESSED WRITTEN
CONSENT OF AGP.

DEMOLITION GENERAL NOTES


1. THESE DEMOLITION PLANS HAVE BEEN PREPARED TO ASSIST THE CONTRACTOR IN DETERMINING THE SCOPE OF DEMOLITION WORK TO BE INCLUDED IN THIS PROJECT. THE CONTRACTOR SHOULD REVIEW ALL DRAWINGS AND SPECIFICATIONS INCLUDING DEMOLITION SHOWN FOR OTHER TRADES, AND BECOME FAMILIAR WITH THE EXISTING CONDITIONS, IN ORDER TO DETERMINE THE SCOPE OF DEMOLITION WORK.
2. EXISTING CONDUIT AND WIRING MAYBE REUSED IF IN SERVICEABLE CONDITION, OTHERWISE PROVIDE NEW CONDUIT AND WIRE AS REQUIRED. NEW DEVICES AND FIXTURES SHALL BE CIRCUITED TO NEW PANELS AS INDICATED. EC SHALL FIELD VERIFY EXISTING CONDITIONS AND REPORT ANY ANOMALIES TO THE ARCHITECT AND ENGINEER PRIOR TO PROCEEDING.
3. DEMOLITION PLAN INFORMATION SHOWN AT TIME OF DESIGN. EC SHALL FIELD VERIFY EXISTING CONDITIONS AND MAKE ANY NECESSARY CHANGES TO COMPLETE THE WORK.
4. REMOVE ALL UNUSED WIRING AND CONDUIT AS PART OF THE DEMOLITION PROCESS.

ELECTRICAL KEYED NOTES

1. EXISTING WATER SOURCE HEAT PUMP TO BE DEMOLISHED AND REPLACED WITH NEW. RETAIN CONDUIT/WIRING FOR CONNECTION TO NEW UNIT. REFER TO SHEET 'E201' FOR ADDITIONAL INFORMATION.
2. DEMOLISH EXISTING ELECTRICAL PANEL. RETAIN BRANCH CIRCUIT FEEDERS FOR RECONNECTION IN NEW ELECTRICAL PANEL. REFER TO SHEET 'E201' FOR MORE INFORMATION.

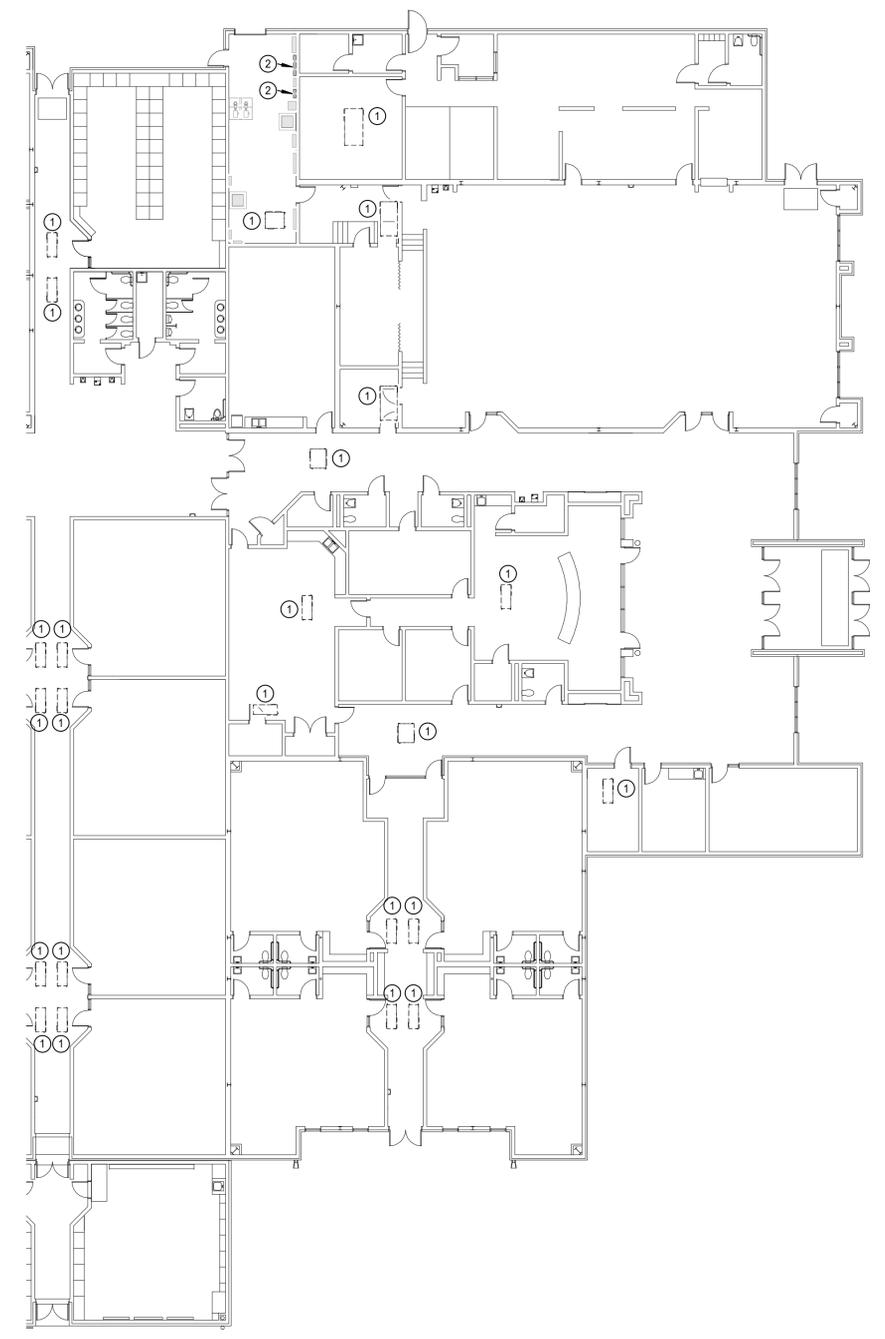

1 ELECTRICAL DEMOLITION POWER PLAN - EAST
Scale: 1/16" = 1'-0"

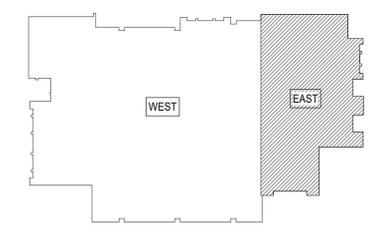

KEY PLAN

Salas O'Brien
Oklahoma City
2900 S. Telephone Road, Suite 120
Moore, OK 73160
CA#: 7058 Expiration Date: 06/30/2027
Salas O'Brien Project Number: 2550-01872-00