



KF
drawn by
DMG
checked by
NOVEMBER 2025
date

REVISIONS

Δ	DESCRIPTION	DATE



WESTMOORE HIGH
SCHOOL 2025
ARENA HVAC

sheet no:
MD201


OWNERSHIP USE OF DOCUMENTS:
AGP EXPRESSLY RESERVES ITS
COPYRIGHT AND OTHER PROPERTY
RIGHTS OF ALL PLANS AND DRAWINGS
DESIGNED AND/OR PRODUCED. PLANS
AND DRAWINGS ARE NOT TO BE
REPRODUCED IN ANY FORM OR MANNER
WITHOUT THE EXPRESSED WRITTEN
CONSENT OF AGP.

GENERAL DEMOLITION NOTES

1. PROVIDE OWNER WITH FIRST RIGHT OF REFUSAL ON ALL DEMO'D EQUIPMENT.
2. DISPOSE OF ALL DEMO'D EQUIPMENT THAT IS NOT BEING RETAINED IN A LEGAL MANNER.
3. PATCH ALL PENETRATIONS THAT ARE NOT BEING REUSED. COORDINATE WITH GENERAL CONTRACTOR.

MECHANICAL KEYED NOTES

1. RTU TO BE DEMOLISHED. EXISTING CURB SHALL BE CUT IN HALF TO PREPARE FOR CURB ADAPTER. COORDINATE WITH G.C. AND ARCHITECT.
2. DEMOLISH DUCTWORK FROM CURB TO LOCATION SHOWN. PATCH AND SEAL PENETRATION UNTIL NEW CONNECTION IS MADE.
3. REMOVE EXISTING 1 1/2" NATURAL GAS LINE IN CEILING SPACE BELOW ROOF AND REPLACE WITH 2" GAS PIPE AND CONNECT TO EXISTING 2" OR LARGER.
4. EXISTING 2" NATURAL GAS LINE IN CEILING SPACE BELOW ROOF.
5. REMOVE EXISTING GAS PIPE AND REPLACE WITH NEW GAS PIPE. REFER TO SHEET M201 FOR NEW SIZES.
6. REMOVE ALL GAS PIPING FROM ROOFTOP UNIT AND ALL PRESSURE REGULATORS AND SHUT-OFF VALVES.
7. DEMOLISH EXISTING CONDENSATE LINE. COORDINATE DEMOLITION OF ELECTRICAL CONNECTIONS AND DISCONNECT AND THERMOSTAT AND WIRING WITH EC.

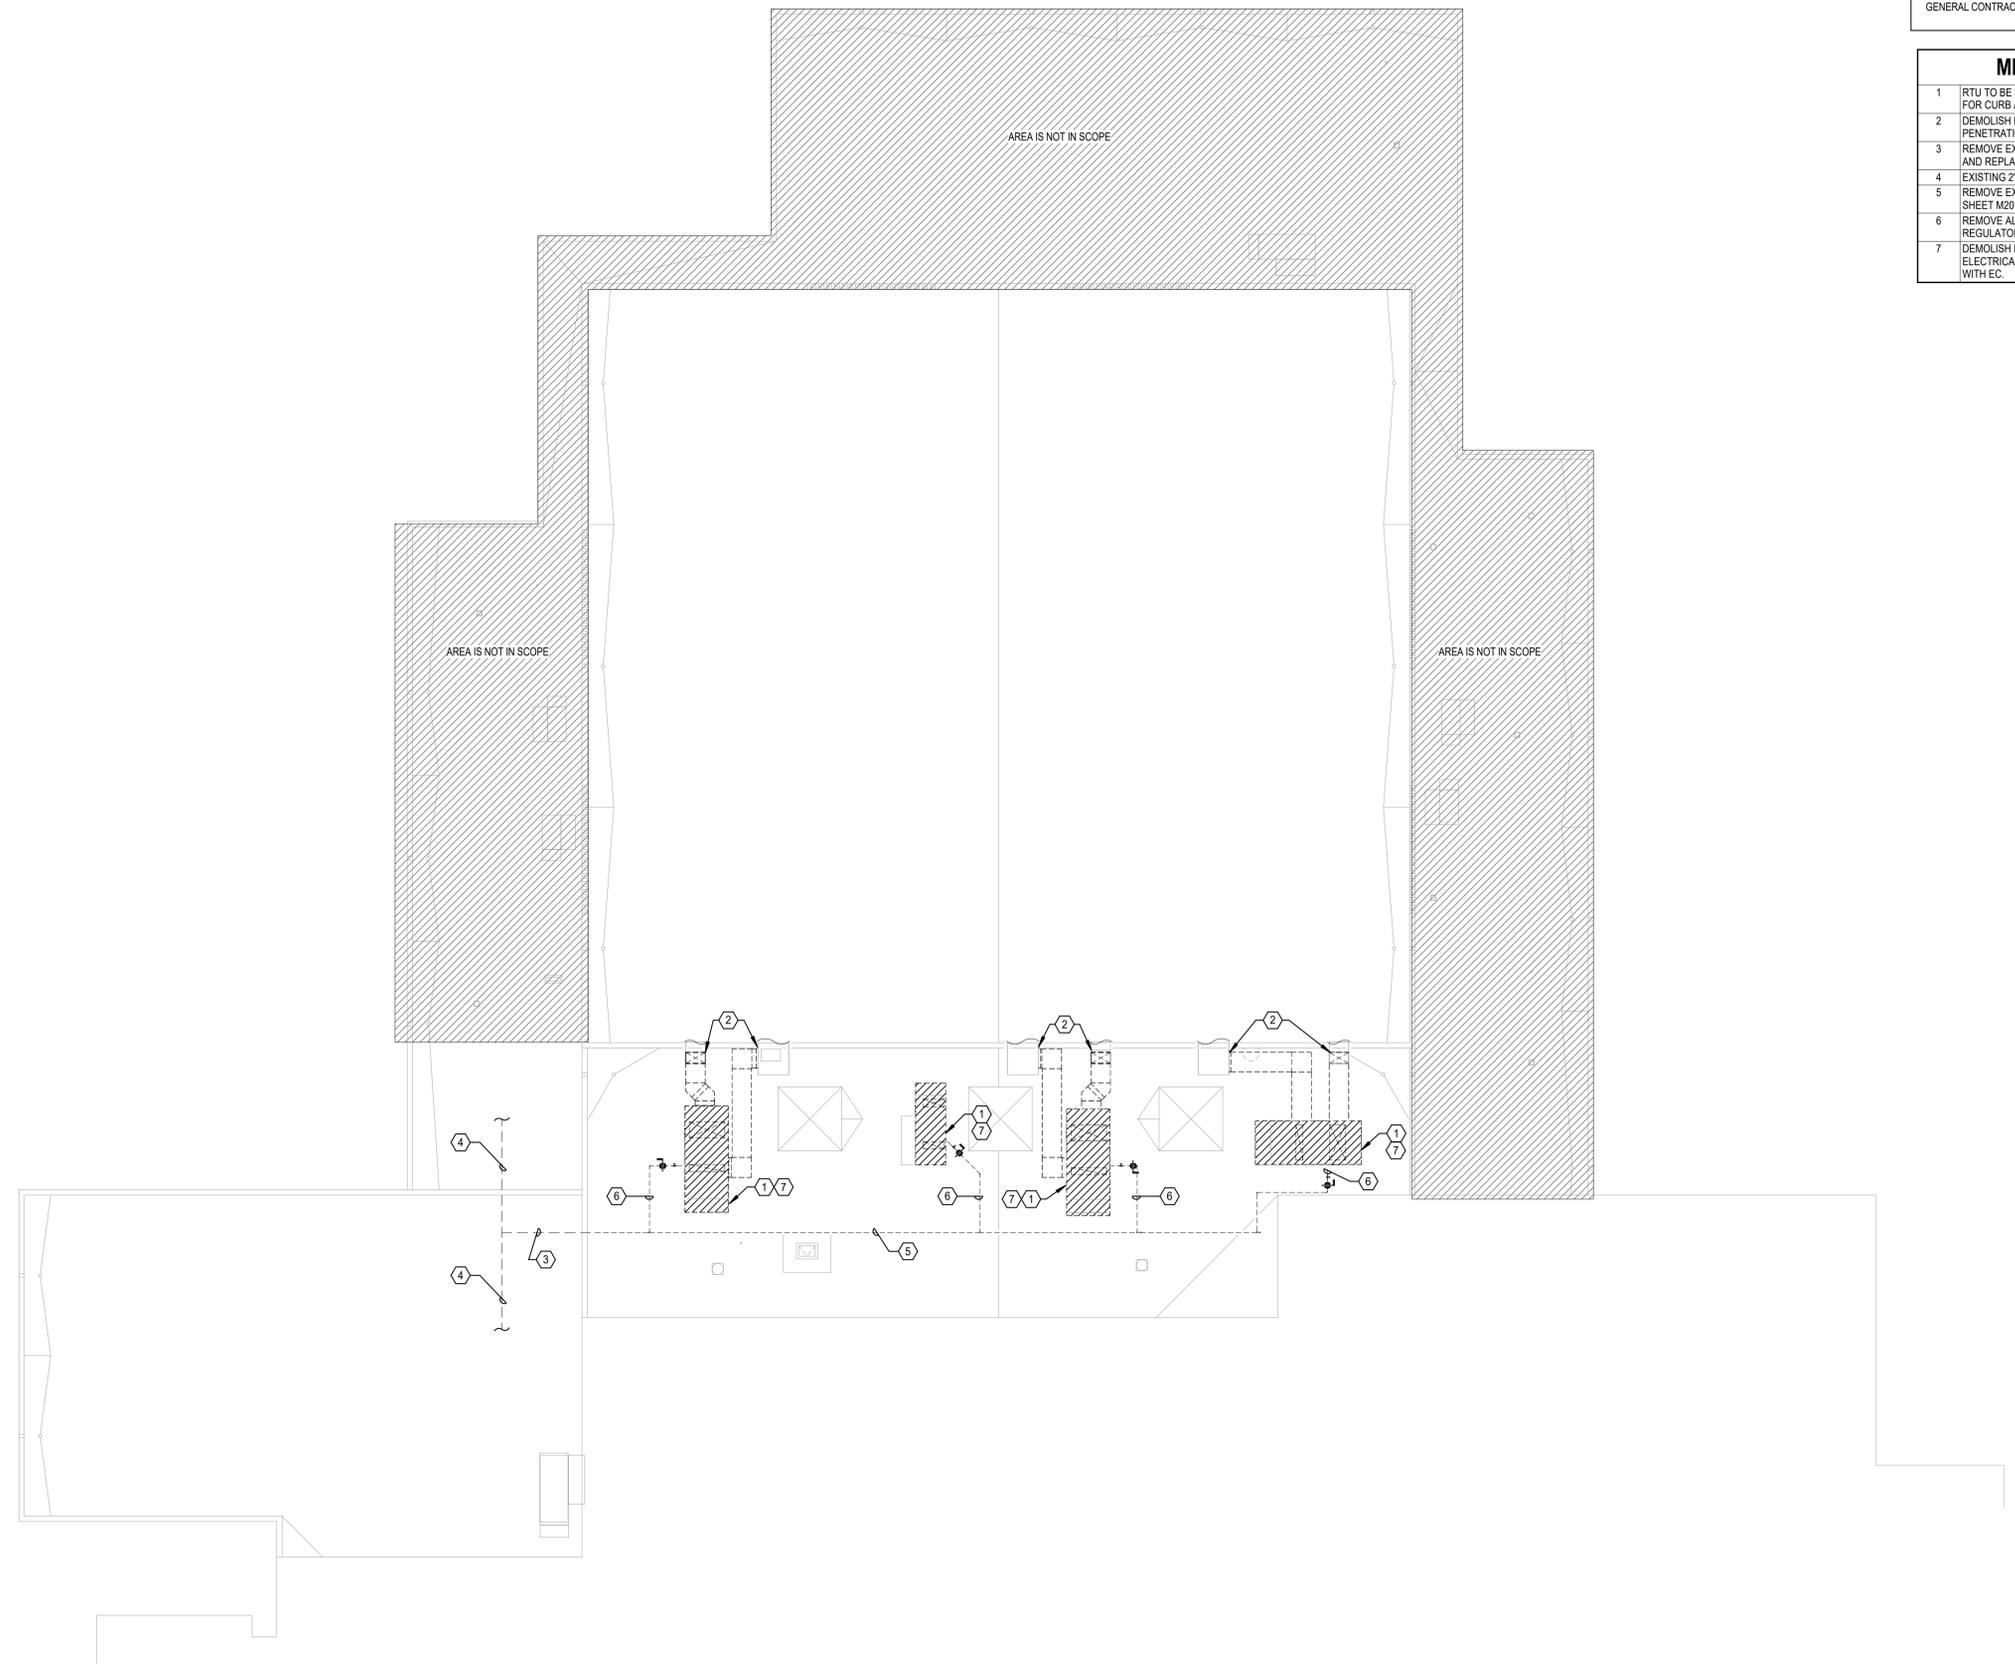

MECHANICAL DEMOLITION ROOF PLAN
Scale: 1/16" = 1'-0"

Salas O'Brien
Oklahoma City
2900 S. Telephone Road, Suite 120
Moore, OK 73160
CA# 7058 Expiration Date: 06/30/2027
Salas O'Brien Project Number: 2550-01871-00